

REV 1

**NORTH ELEVATION**

SCALE: 1/8" = 1'-0"



**EAST ELEVATION**

SCALE: 1/8" = 1'-0"







**SOUTH ELEVATION**

SCALE: 1/8" = 1'-0"



**WEST ELEVATION**

SCALE: 1/8" = 1'-0"

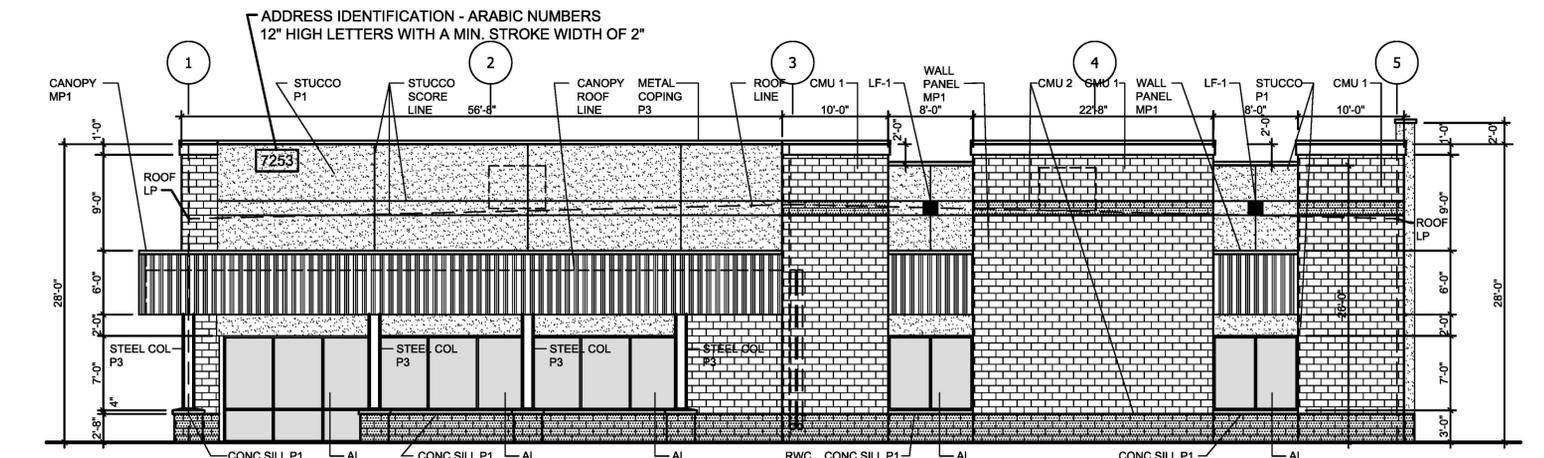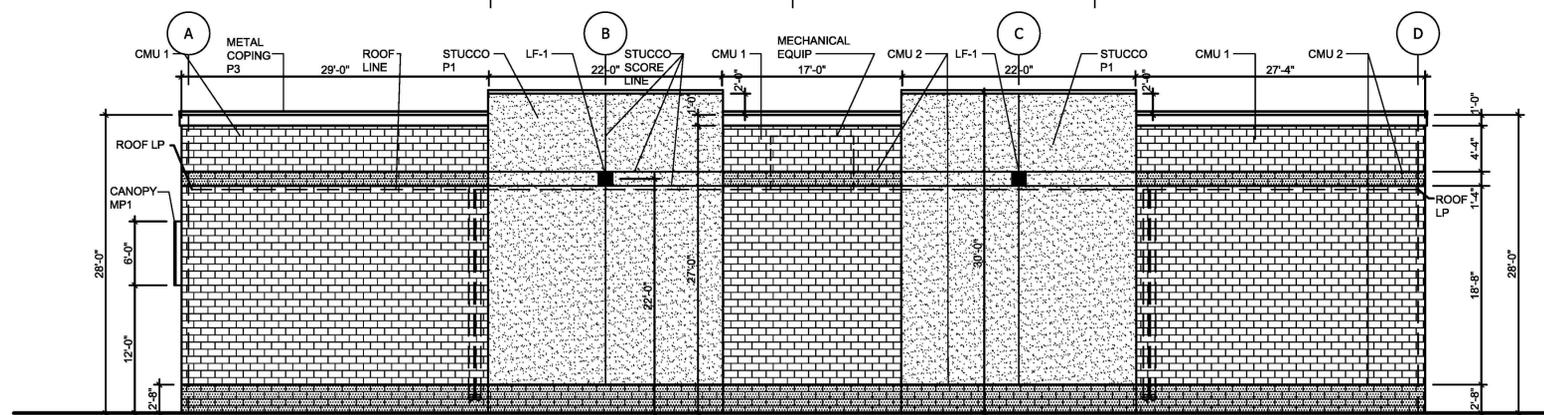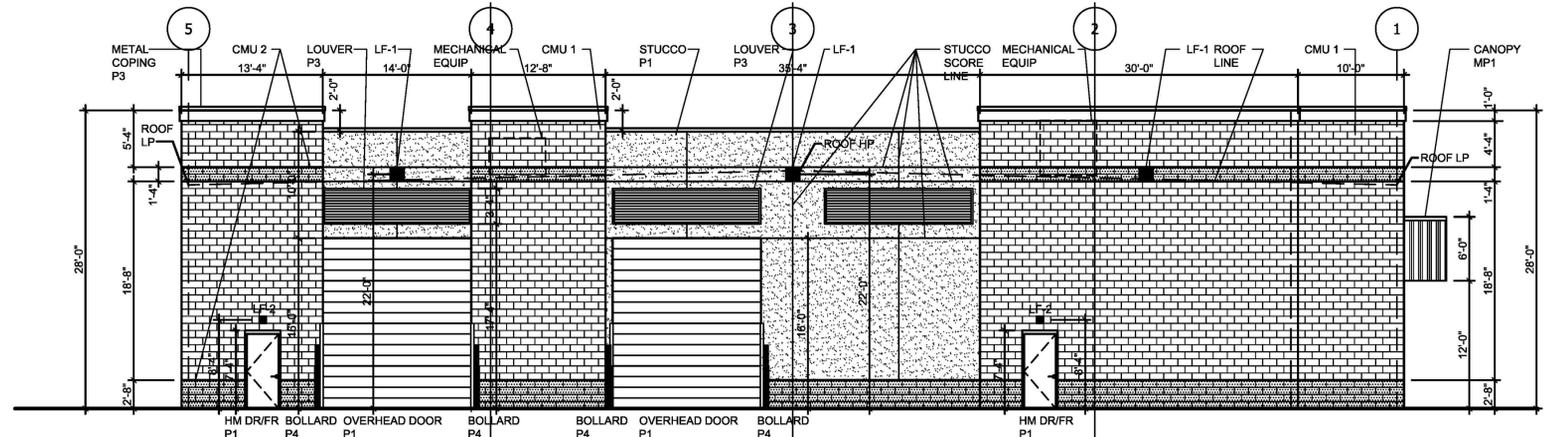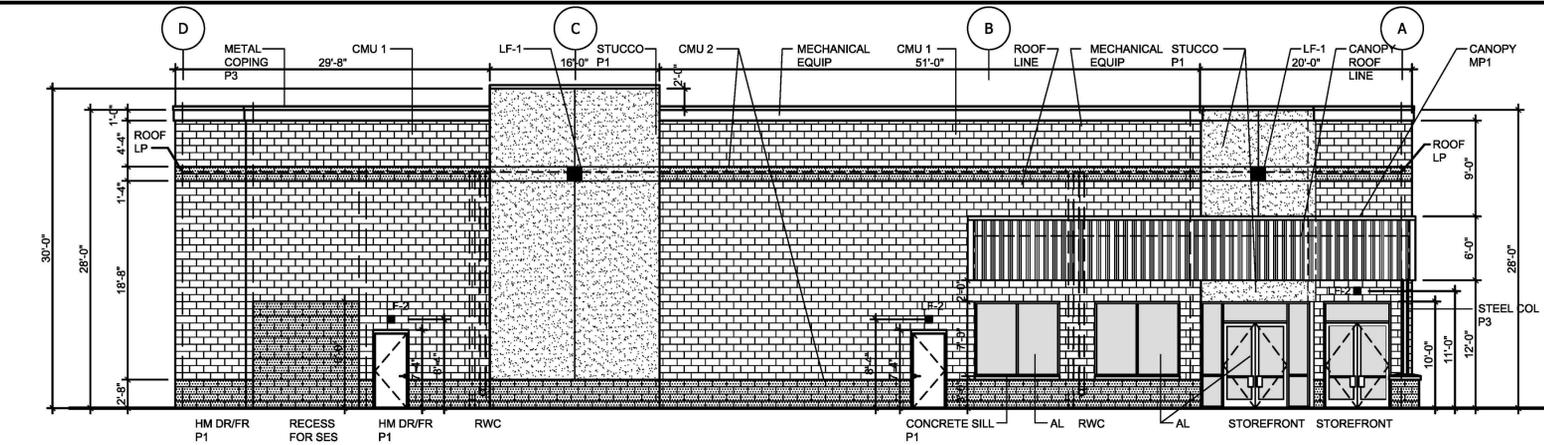

**GENERAL NOTES**

- 1 ALL RAIN WATER CONDUCTORS WILL BE 6" DIAMETER AND WILL BE INTERNALIZED.
- 2 ALL MECHANICAL UNITS WILL BE FULLY SCREENED.

**MATERIALS AND COLORS**

**METAL COPING & FASCIA**

PAC-CLAD, TAPERED 24 GA. STEEL PRE-FINISHED 4" HIGH, WITH 12" HIGH FASCIA CONTINUOUS 24 GA. CLEAT SEALANT AT ALL SPLICES, COLOR TO MATCH STEEL

**AL**

ALUMINUM STOREFRONT SYSTEM  
ARCADIA AFG451T (FRAMING WITH THERMAL BREAK)  
MEDIUM STYLE DOOR, WINDOWS  
COLOR: AB-5, MEDIUM BRONZE  
GLAZING: VITRO SOLARGRAY 90, 1" INSULATING GLASS UNIT VLT 25%, EXT. REFL. 8%, INT. REFL. 11%, U-VALUE (ARGON) 0.24, SHGC 0.22, LSG 1.14

**CMU 1**

CONCRETE MASONRY 8" X 8" X 16" OR 12" X 8" X 16"  
MANUFACTURER: OLD CASTLE- ECHELON  
TYPE: PRECISION (GROUND FACE MASONRY UNIT)  
COLOR: ASPEN  
INSULATED CMU WITH CORE-FILL 500 FOAM INSULATION  
8" CMU, R-8, 12" CMU, R-10

**CMU 2**

CONCRETE MASONRY 8" X 8" X 16" OR 12" X 8" X 16"  
MANUFACTURER: OLD CASTLE- ECHELON  
TYPE: SPLIT FACE  
COLOR: RUTHERFORD GREY  
INSULATED CMU WITH CORE-FILL 500 FOAM INSULATION  
8" CMU, R-8, 12" CMU, R-10

**P1**

PAINT (STUCCO FIELD, HM DOORS/FRAME, OVERHEAD DOORS)  
MANUFACTURER: SHERWIN WILLIAMS  
COLOR: POISED TAUPE SW 6039 232-C5

**P2**

PAINT (CONCRETE SILL)  
MANUFACTURER: SHERWIN WILLIAMS  
COLOR: URBANE BRONZE SW7048 245-C7

**P3**

PAINT (METAL COPING, COLUMNS)  
MANUFACTURER: SHERWIN WILLIAMS  
COLOR: URBANE BRONZE SW7048 245-C7

**P4**

PAINT (BOLLARDS)  
MANUFACTURER: SHERWIN WILLIAMS  
COLOR: SUNFLOWER SW6678 133-C7

**MP1**

METAL PANEL FASCIA  
MANUFACTURER: PAC-CLAD  
MATERIAL: BOX RIB 1, 24 GA. STEEL, 1-3/8" X 12" WIDE  
REFLECTIVITY 0.31, 3 YEAR EXPOSURE 0.31  
EMISSIVITY 0.86, SRI 31  
COLOR: PAC-CLAD STANDARD COLONIAL RED

**OVERHEAD DOOR**

OVERHEAD DOOR COMPANY  
MODEL 418 INSULATED STEEL DOOR  
ELECTRIC OPEN/CLOSE  
R-VALUE -7.35

**LIGHT FIXTURES (EXTERIOR WALL)**

LF-1 VISA LIGHTING OW1725 - SOUTHRIDGE - DECORATIVE SCENCE  
18" W X 18" H X 5.5" D  
SOURCE L30K(L), CCT 3000K, DELIVERED LUMENS 1400, POWER 31 WATTS  
COLOR: TRCN - TERRACOTTA CANYON

**LF-2**

LITHONIA LIGHTING - D SERIES SIZE 2 LED WALL LUMINAIRE  
5.5" W X 4" H X 1.5" D  
SERIES DSXW2LED, LUMEN PACKAGE P4 7200 LUMENS, CCT 30K 3000K  
COLOR: ddb - DARK BRONZE

**RWC**

JOSAM 25010 DOWNSPOUT NOZZLE  
MATERIAL: BRONZE  
SIZE: 6" OVERFLOW DRAIN, LOCATE 18" A.F.



**ARCHICON**

Architecture & Interiors, L.C.

5055 E WASHINGTON STREET  
SUITE 200  
PHOENIX, ARIZONA 85034  
(602) 222-4266  
FAX (602) 279-4305  
www.ARCHICON.COM

**NEW LIGHT INDUSTRIAL DEVELOPMENT**  
**GATEWAY AIRPORT COMMERCE PARK LOT 19**  
**7253 S. 89TH PLACE**  
**MESA, AZ 85212**

PROJECT NUMBER: 2537540-01  
PROJECT MANAGER: MDM  
DRAWN BY: MDM  
CHECKED BY: JP

DRB SUBMITTAL	25.12.16
1 DRB COMMENTS	26.1.22

**SHEET DESCRIPTION**  
**ELEVATIONS**



SHEET NO.

**DR300**  
ISSUE DATE: 25.12.16

