


REVISIONS		
NO.	DATE	DESCRIPTION

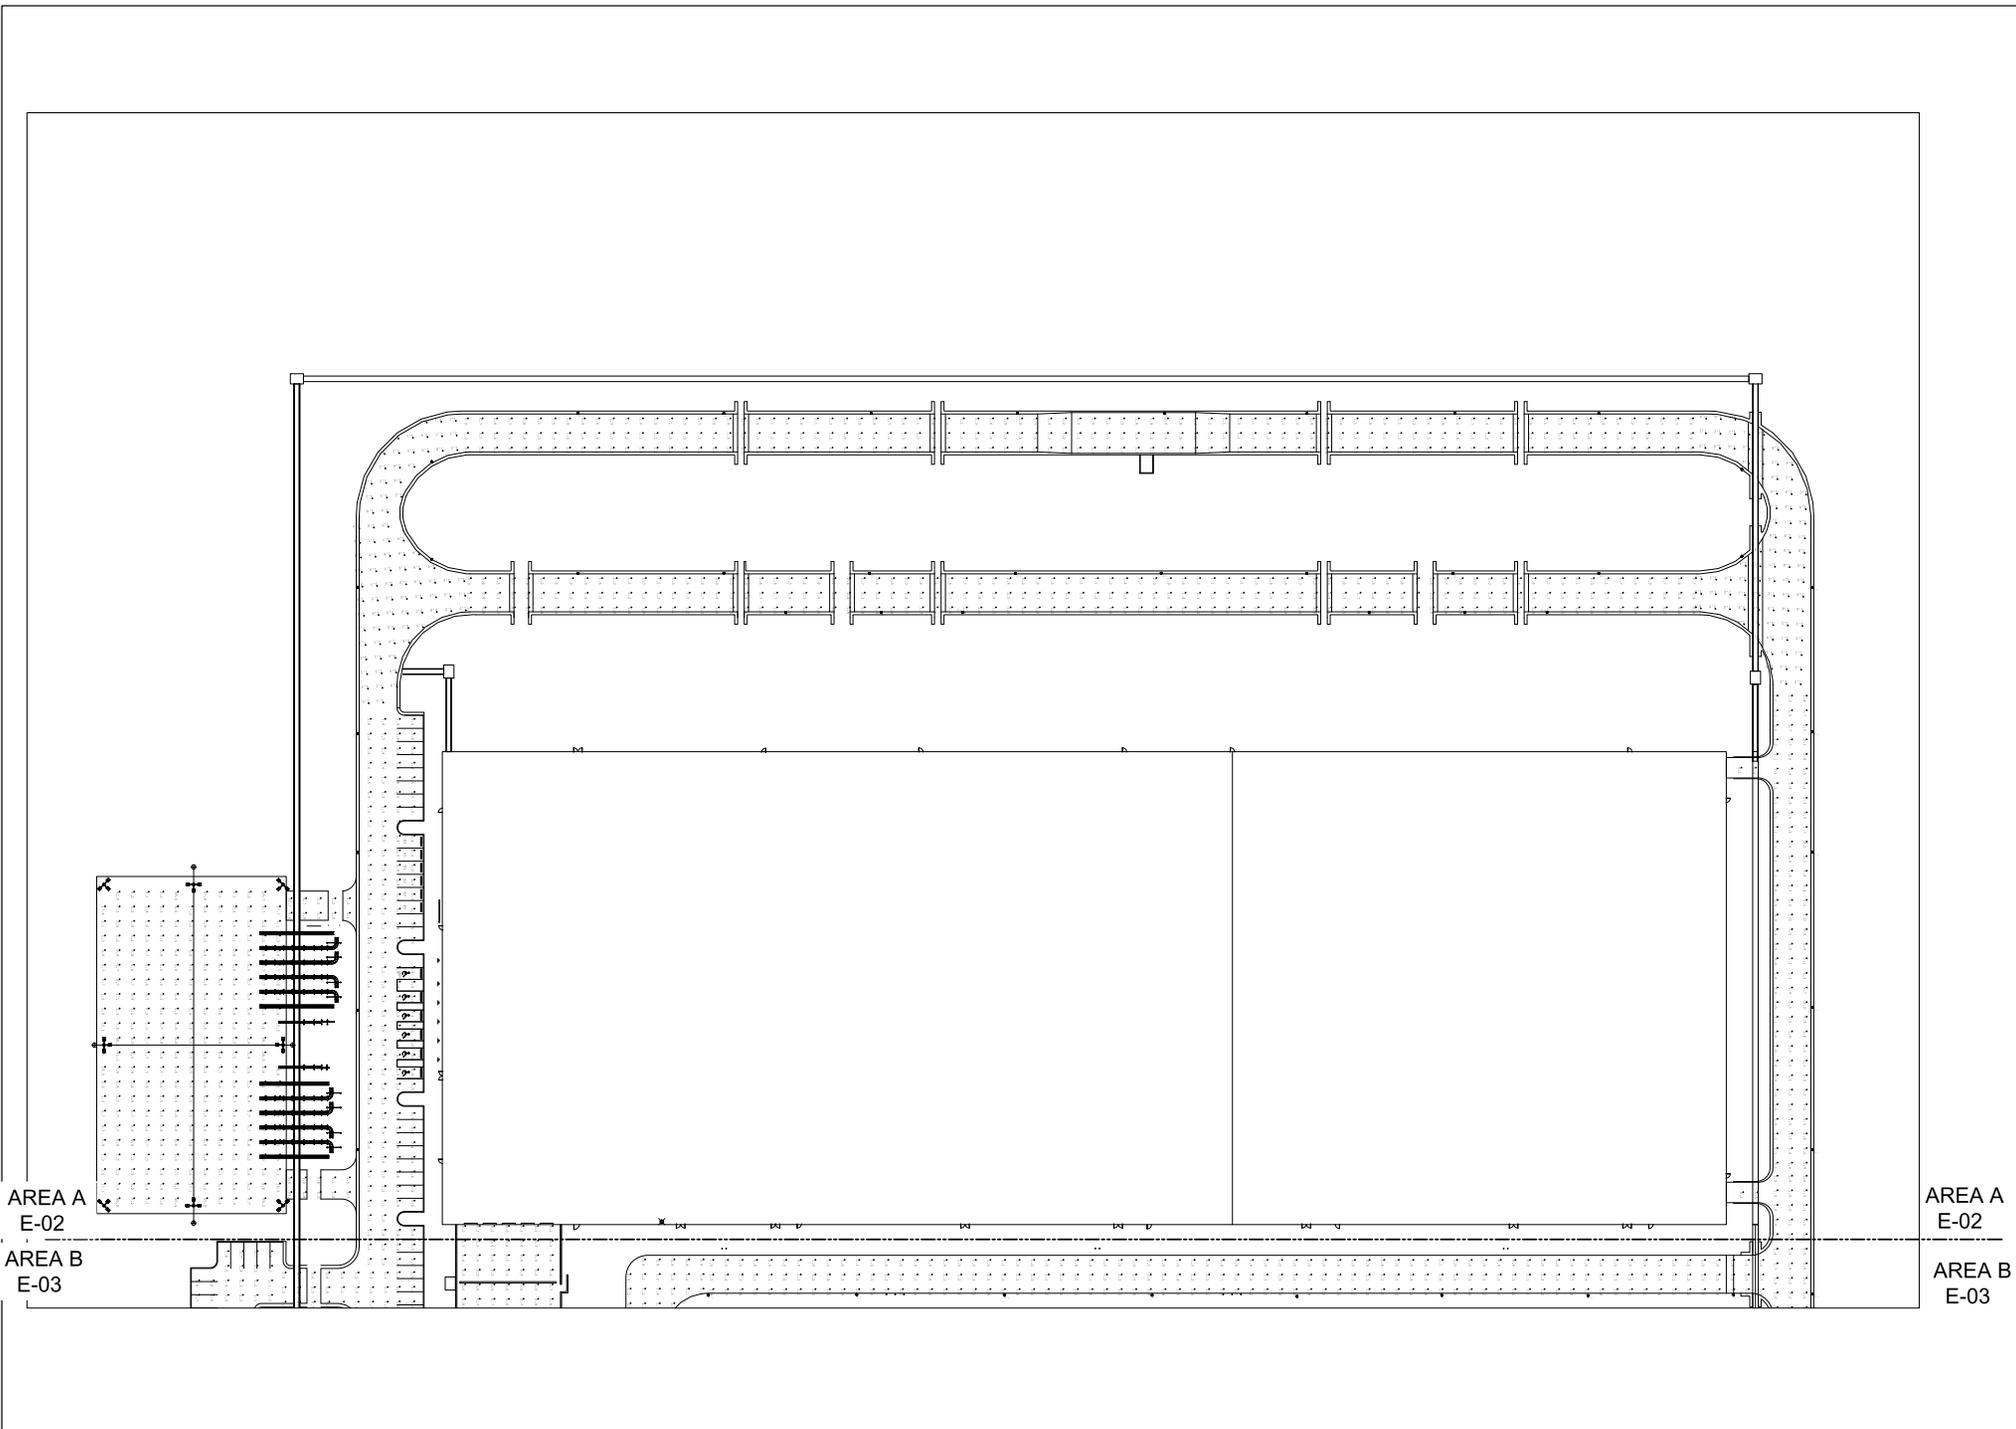

AREA A  
E-02

 
AREA B  
E-03

AREA A  
E-02

AREA B  
E-03



CONFIDENTIAL CLIENT  
NOT FOR CONSTRUCTION




REVISIONS		
NO.	DATE	DESCRIPTION

DRAWN: MSA3A  
PROJECT ADDRESS:  
7201 E. SILVER RD.  
MESA, AZ 85212  
PROJ. NO.:

SITE LIGHTING PLAN  
PHOTOMETRIC CALCULATIONS -  
AREA A  
SCALE: 1" = 30'-0"

SHEET NUMBER:  
E-02

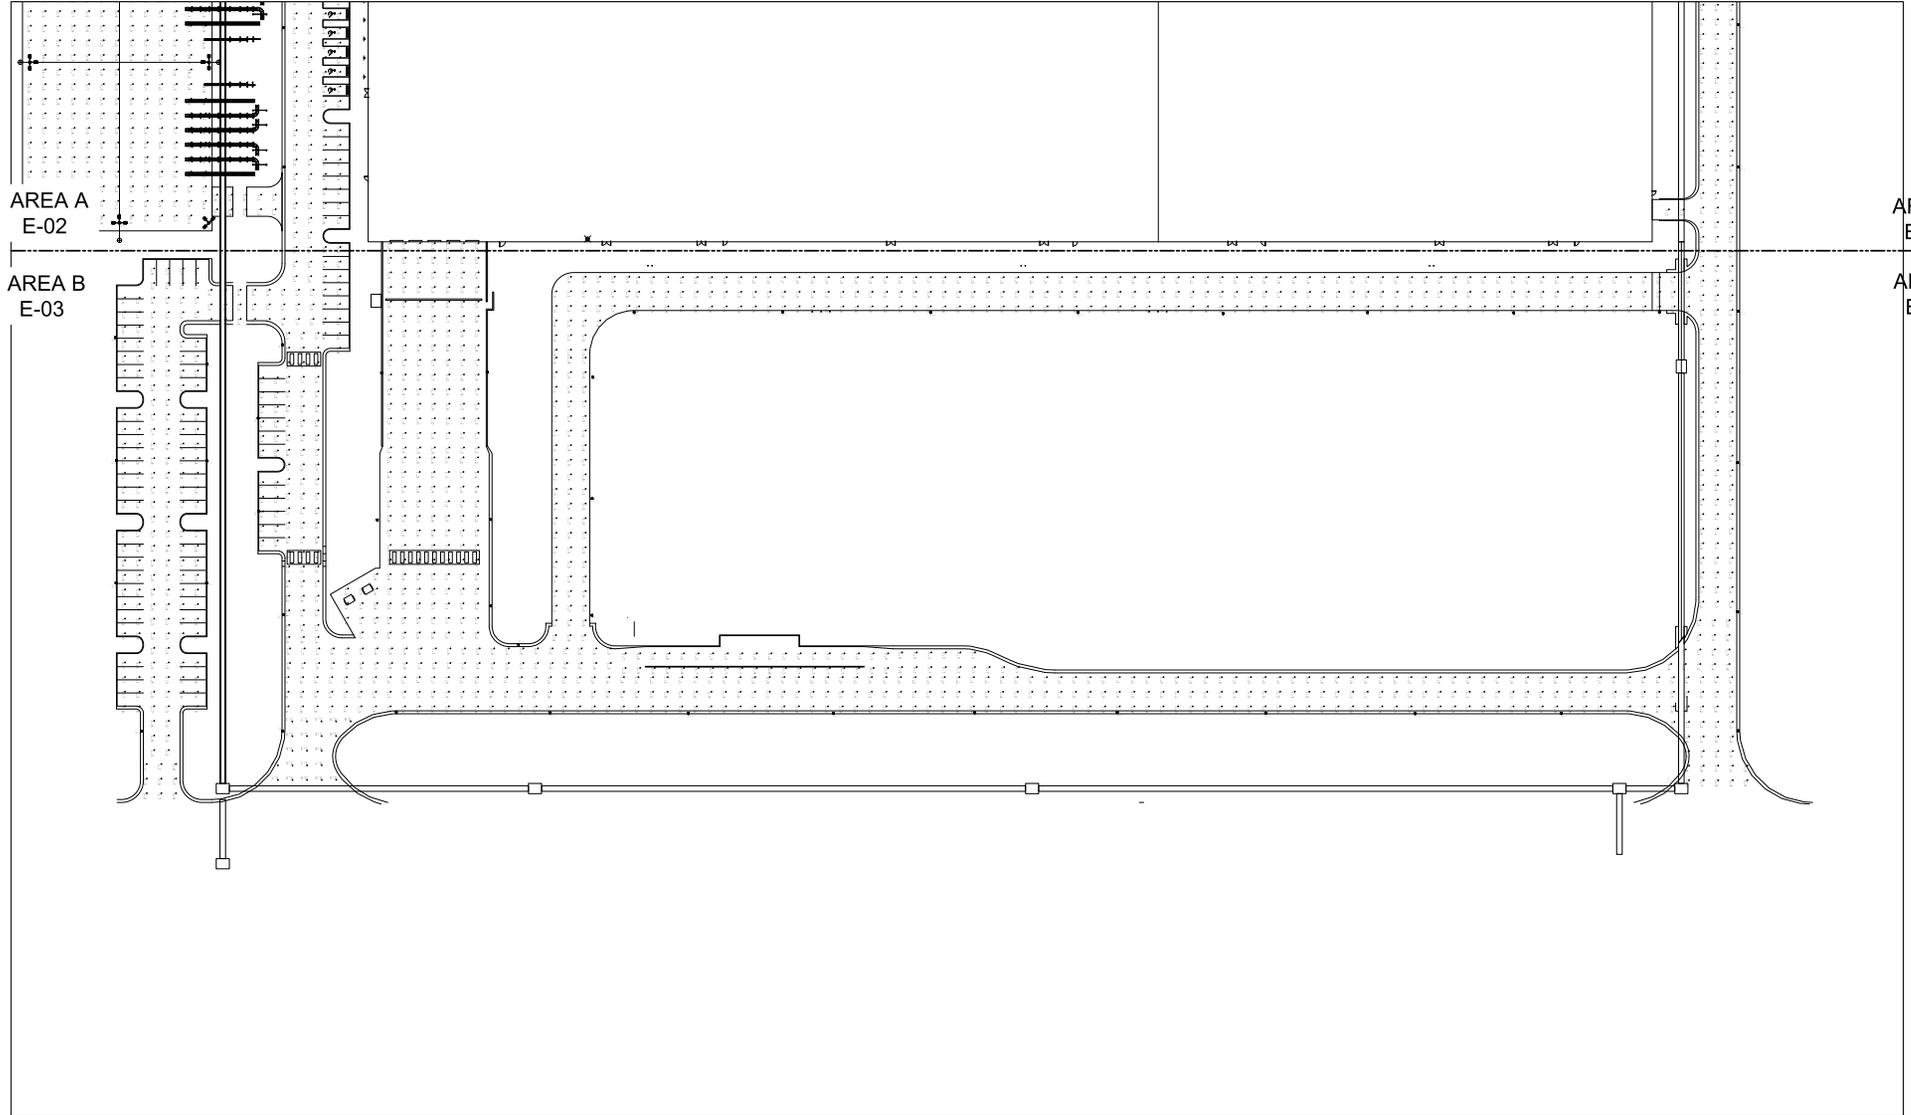

REVISIONS		
NO.	DATE	DESCRIPTION

DRAWN: MSA3A  
 APPRVD:  
 PROJECT ADDRESS:  
 7201 E. SILVER RD.  
 MESA, AZ 85212  
 PROJ. NO.:

SITE LIGHTING PLAN  
 PHOTOMETRIC CALCULATIONS -  
 AREA B  
 SCALE: 1" = 30'-0"

SHEET NUMBER:  
**E-03**