1. COORDINATE EXACT LOCATIONS OF LUMINAIRE WITH ARCHITECTURAL REFLECTED CEILING PLAN.

DESCRIPTION

POLE-MOUNTED @ 10FT

POLE-MOUNTED @ 15FT

RECESSED CANOPY LIGHT

2. LUMINAIRE WITH CATALOG NUMBER TO SET MINIMUM LEVEL OF QUALITY, MATCH FIXTURE BASED ON CATALOG NUMBER FOR OTHER MANUFACTURERS.

SITE LUMINAIRE SCHEDULE

CATALOG NUMBER

DSXWPM LED IOC 350 30K T2M MVOLT

DSX0 LED PI 30K T3M MVOLT HS

DSX0 LED PI 30K T5S MVOLT

WDGEI LED PI 30K 80CRI VW

LRC-08KLD-1000L-UNV-SKL-WFL-30K

MANUFACTURER

LITHONIA


LITHONIA

LITHONIA

LITHONIA

KIRLIN

3. COORDINATE MOUNTING WITH CEILING TYPES AND ARCHITECTURAL CEILING PLANS FOR FLANGES AND HARDWARE KITS.

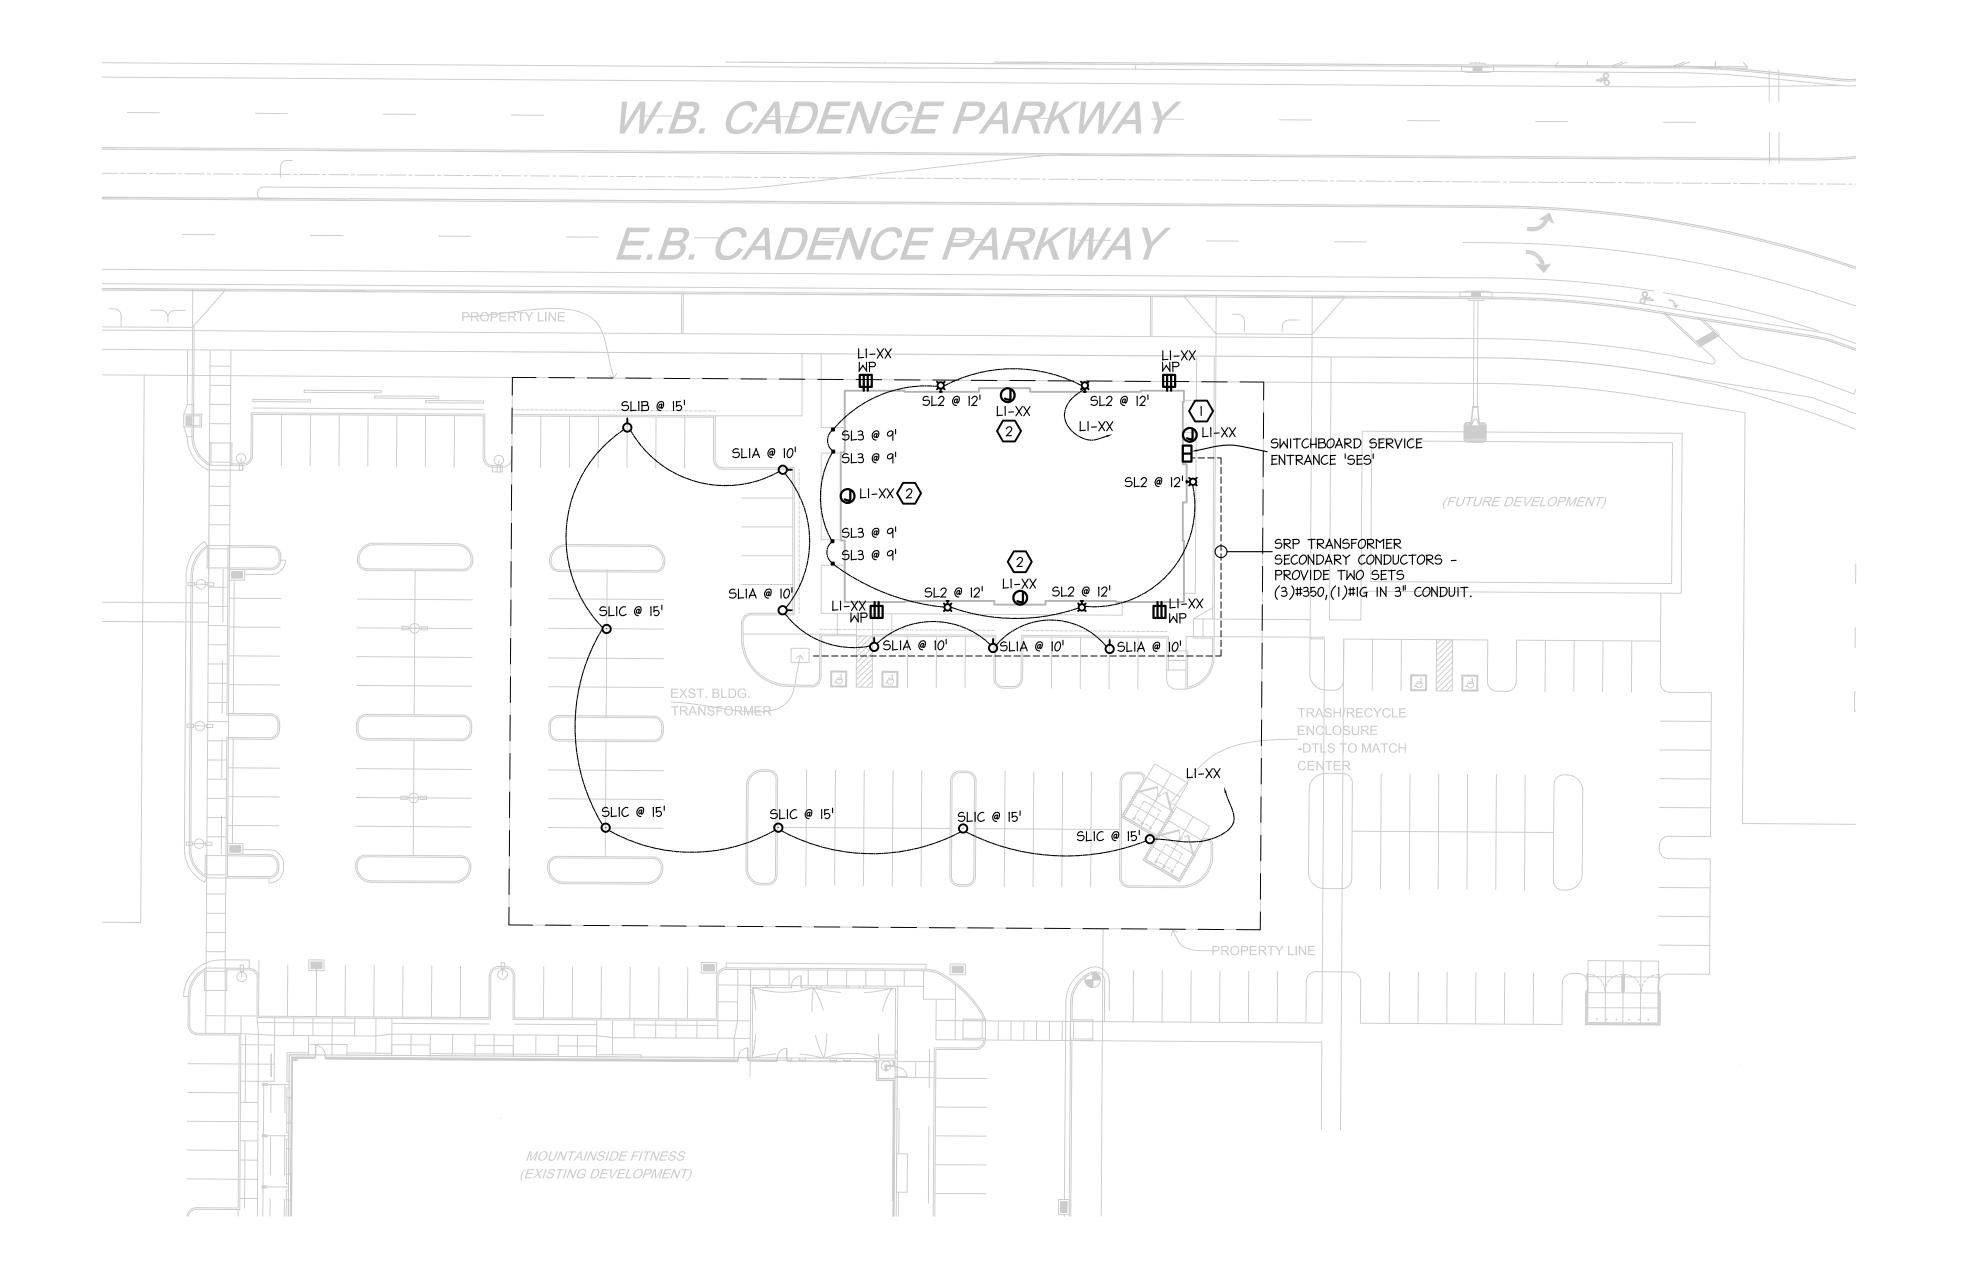

LAMP DATA

COLOR TEMP

3000K

3000K

3000K

3000K

3000K

LUMENS

1349

4376

4552

1200

1000

WATTS

VOLTS

MVOLT

MVOLT

MVOLT

MVOLT

MVOLT

NOTES

1, 2, 3

1, 2, 3

1, 2, 3

TYPE

LED

LED

LED

LED

LED

ALTERNATE

MANUFACTURER

 
TBD

TBD

TBD

TBD





LIGHTING NOTES:

1. UNLESS OTHERWISE NOTED, COORDINATE EXACT MOUNTING HEIGHTS OF ALL DEVICES WITH ARCHITECTURAL ELEVATIONS.

\(\sigma\) LIGHTING KEY NOTES:

PROVIDE 120V CONNECTION TO IRRIGATION CONTROLLER.

2 PROVIDE 120V CONNECTION TO BUILDING SIGNAGE.

eleventh floor phoenix az 85012 mail@owp.com

2929 n central ave.

602.257.1764 t 602.257.9029 f

www.owp.com

Expires 03/31/2024

© 2021 this (hard copy or electronic) drawing is an instrument of service and the property of © 2021 this (hard copy or electronic) drawing is an instrument of service and the property of the Orout Winslow Partnership and shall remain their property. The design professional shall not be responsible for any alterations, modifications or additions made to this drawing by any party other than the design professional. Use of this drawing shall be limited to the original site for which it was prepared and publication thereof is expressly limited to such use, re-use or reproduction. Unless otherwise agreed in writing, design professional reserves all copyright or other proprietary interest in this drawing, and it may not be re-used for any other purpose without the design professional's written consent. Publication by any method in whole or part is prohibited without the written permission of the design professional. Any information obtained or conclusions derived from this drawing shall be at the user's sole risk.

0

CLIENT CONTACT

Children's H

602.933.0481 t Dave Cottle 1919 East Thomas Road #Client Fax f Phoenix, Arizona 85016 dcottle@phoenixchildrens.com

PROJECT NO.

DATE OF ISSUE 05/26/2022

REVISION NO. DATE

PROJECT TEAM

DRAWN BY Thomas Chasty

PROJECT PHASE **Conceptual Design**

SHEET CONTENTS

ELECTRICAL SITE PLAN

SHEET NO.

E100

PHOTOMETRIC DATA

CALCULATION ZONE	SYMBOL	MAXIMUM (FC)	AVERAGE (FC)
PARKING LOT ILLUMINANCE	+	3.1	0.9
PROPERTY LINE SPILL LIGHT	X	0.4	0.0

mail@owp.com 602.257.1764 t 602.257.9029 f

2929 n central ave. eleventh floor

phoenix az 85012

www.owp.com



© 2021 this (hard copy or electronic) drawing is an instrument of service and the property of the Orcutt (Winslow Partnership and shall remain their property. The design professional shall not be responsible for any alterations, modifications or additions made to this drawing by any party other than the design professional. Use of this drawing shall be limited to the original site for which it was prepared and publication thereof is expressly limited to such use, re-use or reproduction. Unless otherwise agreed in writing, design professional reserves all copyright or other proprietary interest in this drawing, and it may not be re-used for any other purpose without the design professional's written consent. Publication by any method in whole or part is prohibited without the written permission of the design professional. Any information obtained or conclusions derived from this drawing shall be at the user's sole risk.

CLIENT CONTACT

602.933.0481 t Dave Cottle 1919 East Thomas Road #Client Fax f Phoenix, Arizona 85016 dcottle@phoenixchildrens.com

PROJECT NO.

05/26/2022 REVISION NO.

DATE

DATE OF ISSUE

PROJECT TEAM DRAWN BY


Thomas Chasty


PROJECT PHASE Conceptual Design


SHEET CONTENTS

ELECTRICAL SITE PHOTOMETRIC PLAN SHEET NO.


E100A

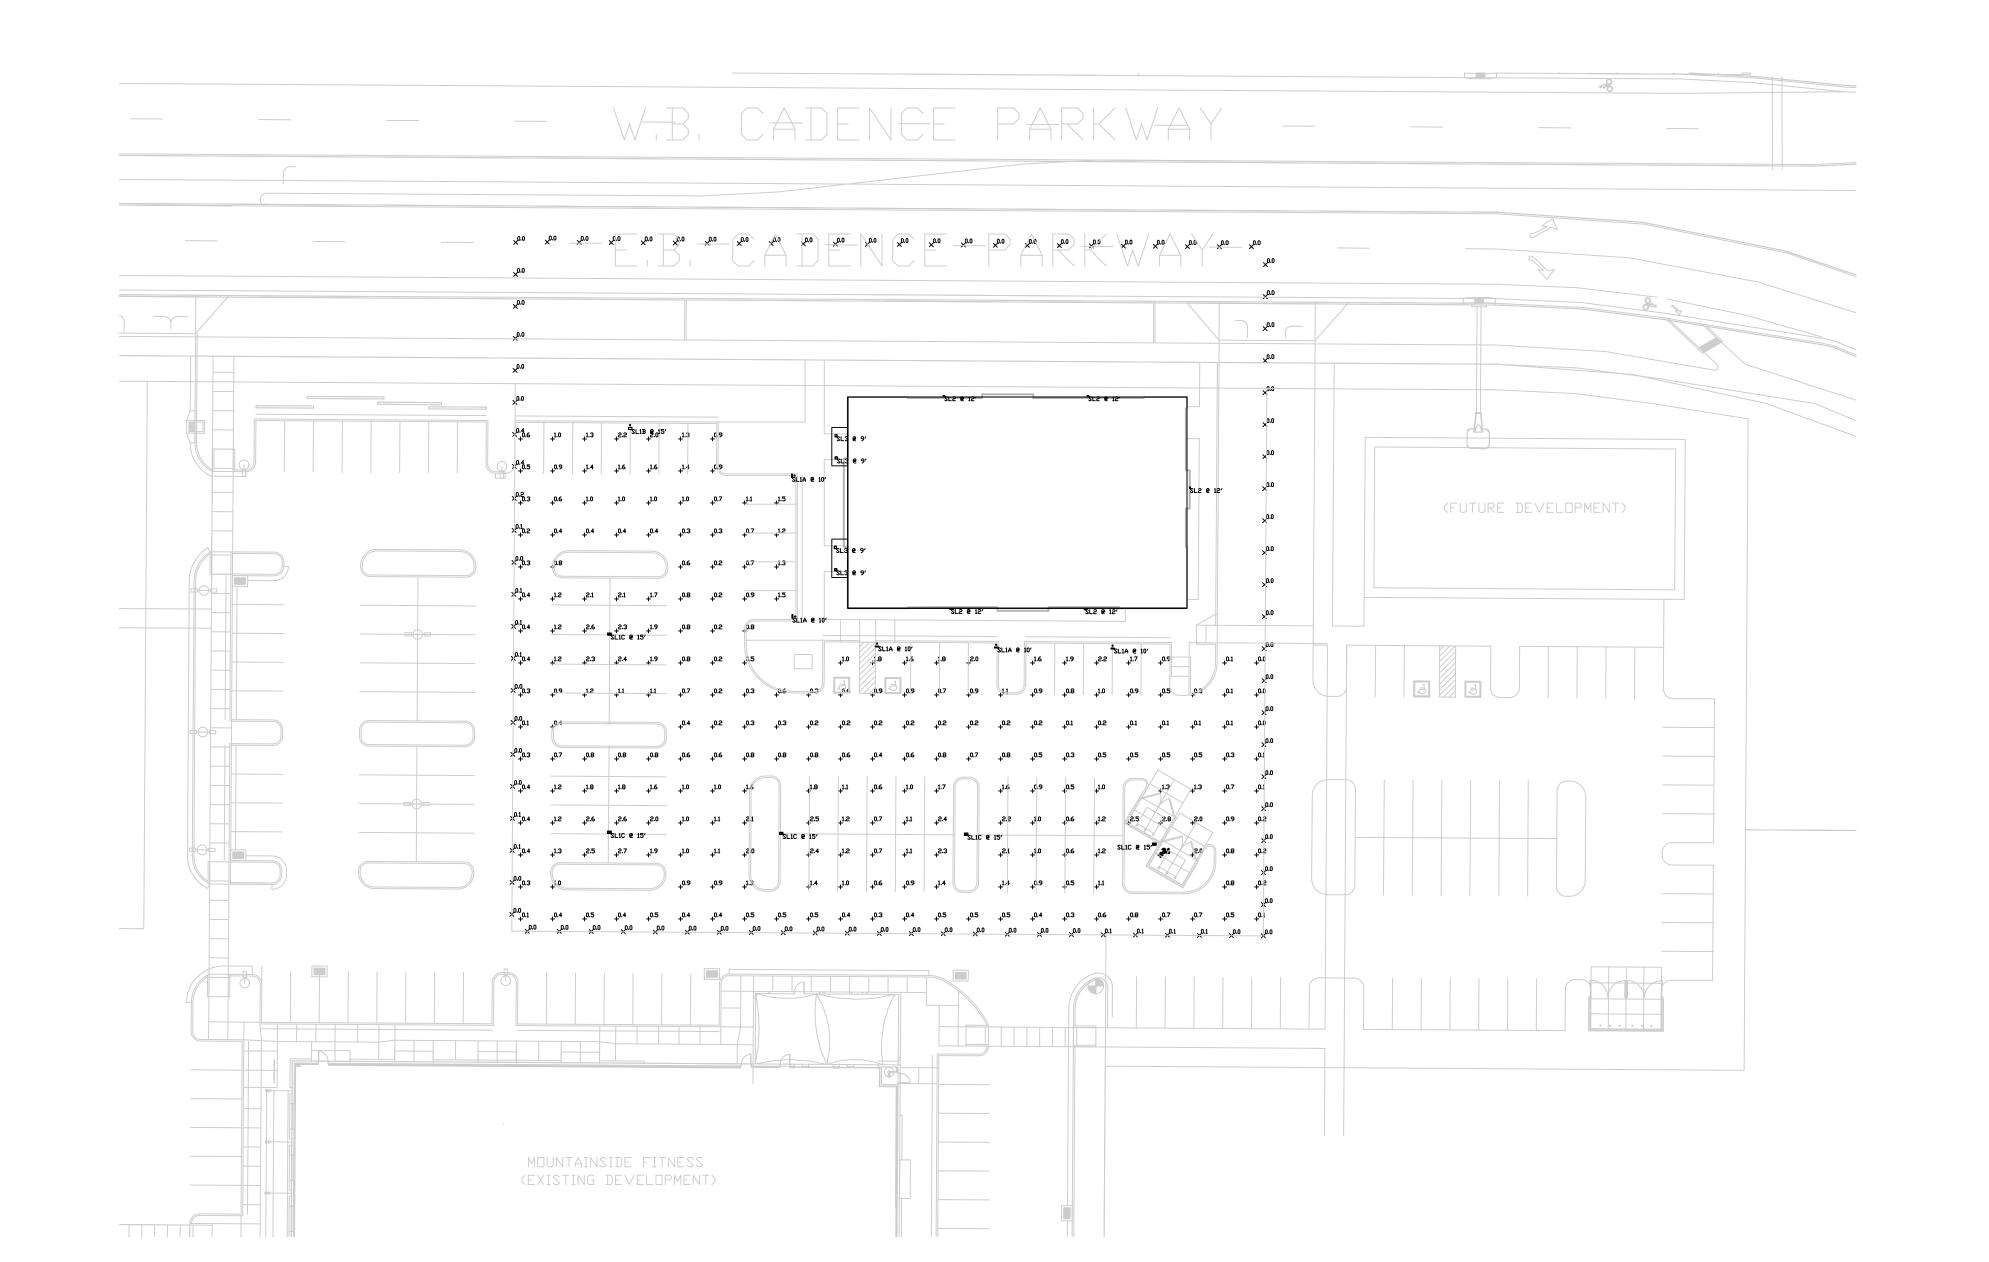


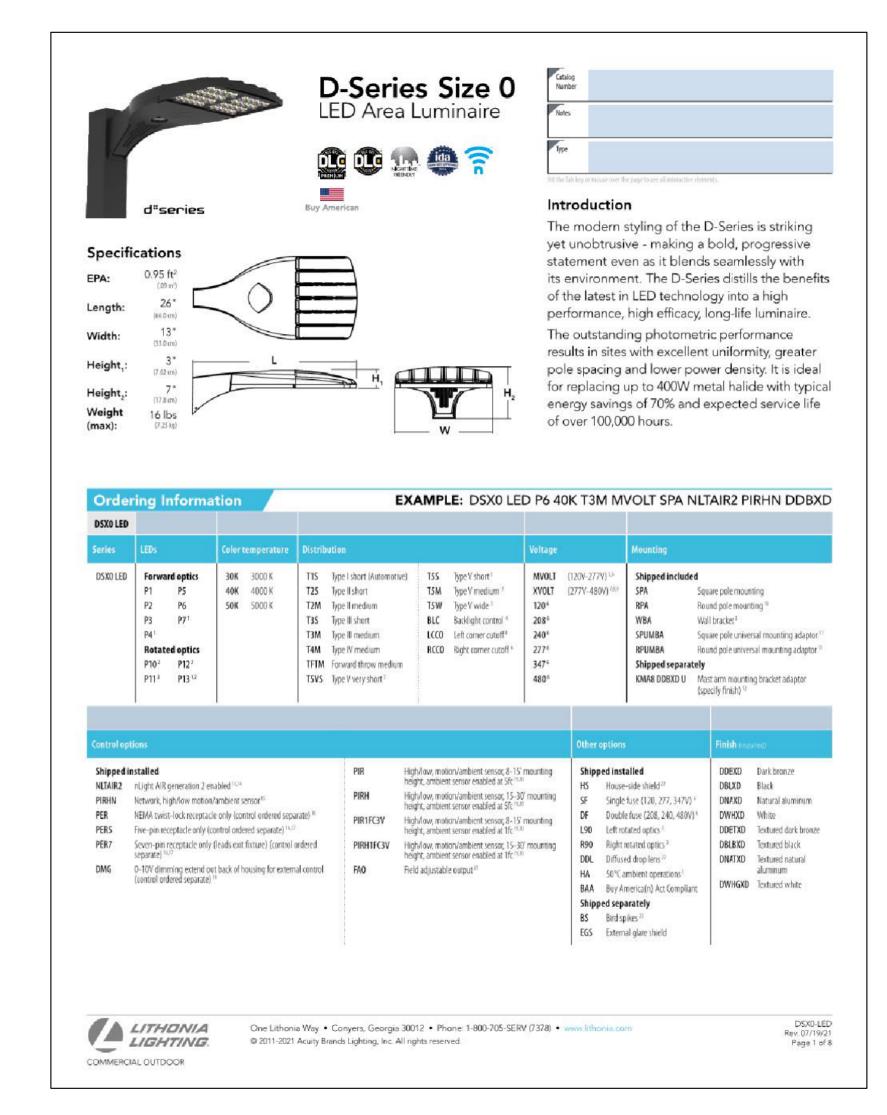

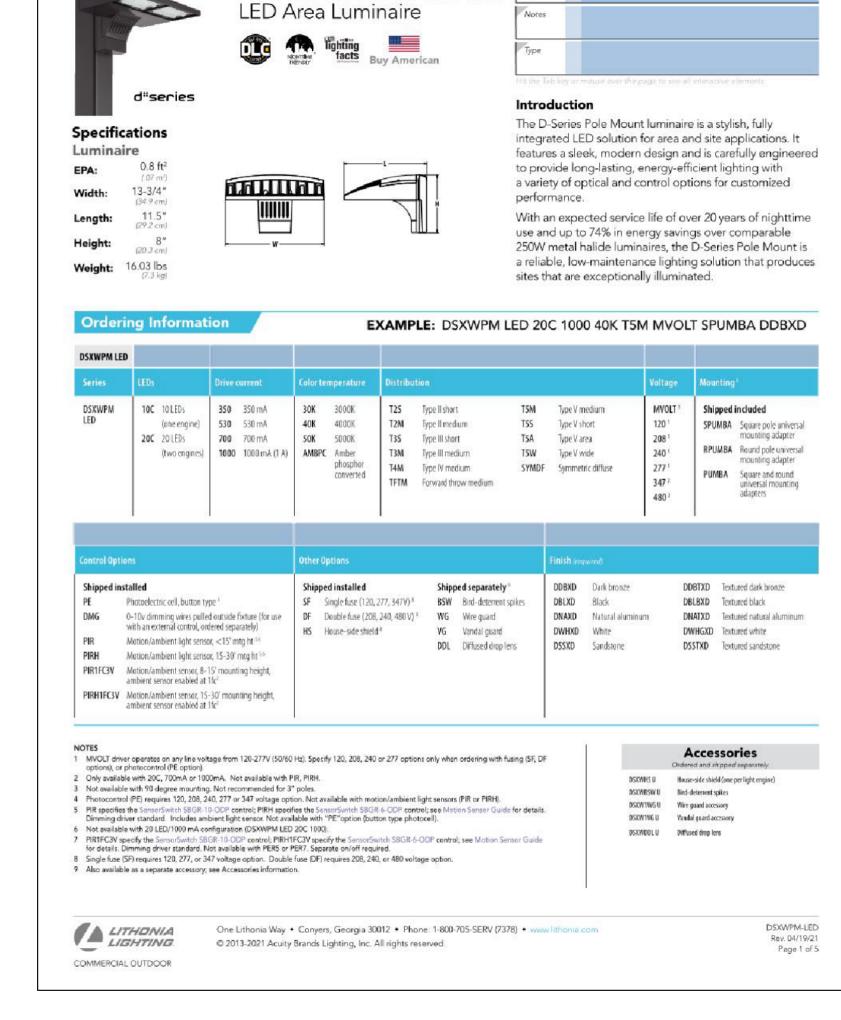

D-Series Pole Mount

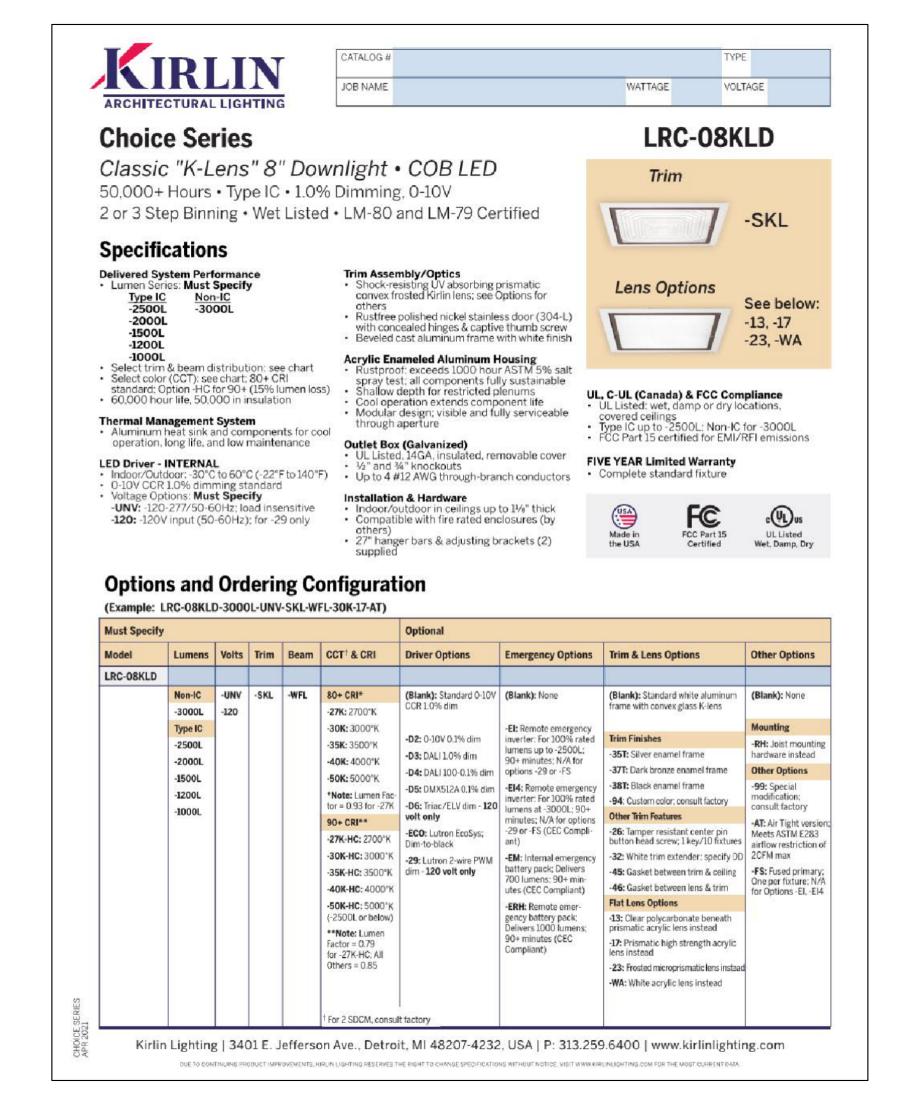

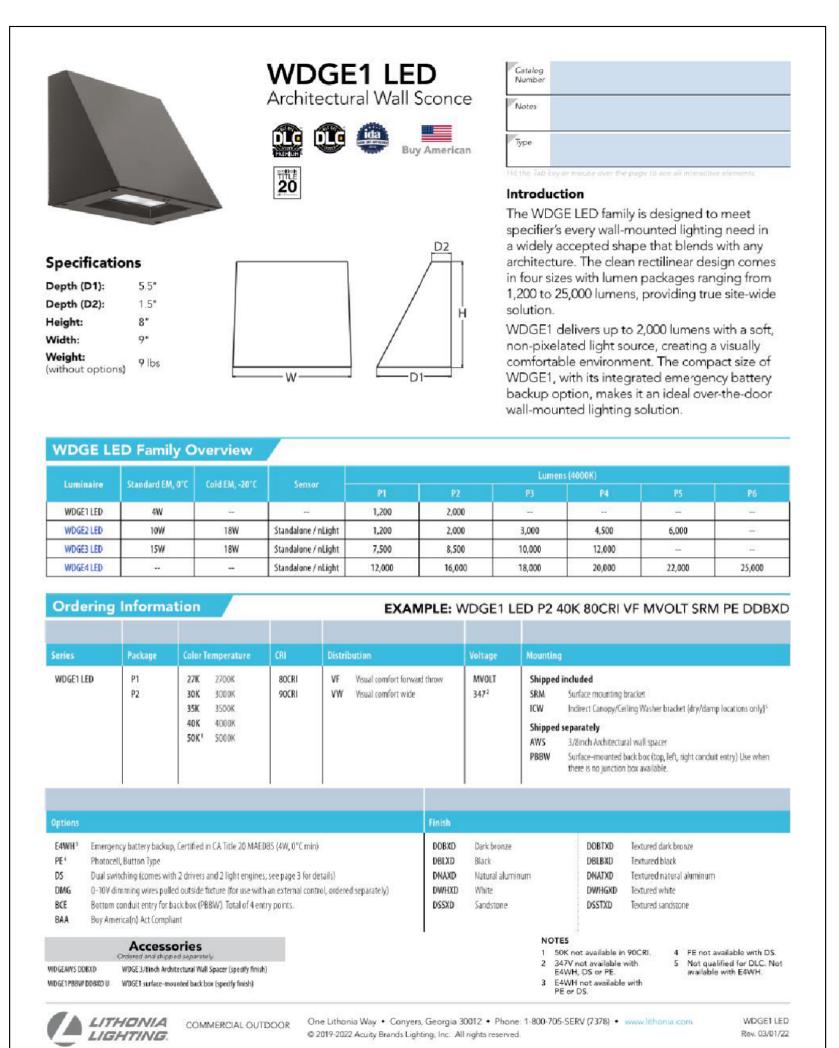

2929 n central ave. eleventh floor phoenix az 85012

mail@owp.com 602.257.1764 t

602.257.9029 f www.owp.com



© 2021 this (hard copy or electronic) drawing is an instrument of service and the property of the Orcuttl Winslow Partnership and shall remain their property. The design professional sha not be responsible for any alterations, modifications or additions made to this drawing by any party other than the design professional. Use of this drawing shall be limited to the original sit reproduction. Unless otherwise agreed in writing, design professional reserves all copyright or other proprietary interest in this drawing, and it may not be re-used for any other purpose without the design professional's written consent. Publication by any method in whole or part is prohibited without the written permission of the design professional. Any information obtained or conclusions derived from this drawing shall be at the user's sole risk.

> **6** 0 ω

CLIENT CONTACT

ospital

Children's

Phoenix

602.933.0481 t Dave Cottle 1919 East Thomas Road #Client Fax f Phoenix, Arizona 85016 dcottle@phoenixchildrens.com

PROJECT NO.

DATE OF ISSUE 05/26/2022

DATE REVISION NO.

PROJECT TEAM

Thomas Chasty

PROJECT PHASE **Conceptual Design**

SHEET CONTENTS

ELECTRICAL SITE LUMINAIRE CUT SHEETS SHEET NO.

DRAWN BY

E100B