

EXISTING LEGEND:

POWERPOLE —ss— SAN. SEWER LINE MONUMENT FOUND SEWER MANHOLE MONUMENT SET GUY WIRE LIGHT POLE P.K. NAIL FOUND G GREASE TRAP ☐ P.K. NAIL SET GROUND LIGHT -FM- FORCE MAIN STREET LIGHT POLE MAG NAIL FOUND CLEAN OUT MAG NAIL SET ELEC. TRANSFORMER -SD-STORM DRAIN LINE AC AIR CONDITIONER X FOUND X MARK STORM DRAIN MANHOLE — E — BURIED ELECTRIC imes SET X MARK SI STORM INLET OVERHEAD ELECTRIC ▲ R.R. SPIKE FOUND ELECTRIC MANHOLE △ R.R. SPIKE SET ELECTRIC METER CURB INLET ELECTRIC BOX BENCHMARK A PAY PHONE GENERATOR R/W CONC. R/W MARKER TELEPHONE BOX ELECTRICAL VAULT (R) RECORD DATA TELEPHONE PEDESTAL E ELECTRICAL PEDESTAL (M) MEASURED DATA TELEPHONE MANHOLE (C) CALCULATED DATA TELEPHONE POLE WATER MANHOLE R/W RIGHT OF WAY -TELEPHONE LINE WATER VALVE O/HT OVERHEAD TELEPHONE UNDERGROUND

TELEPHONE MARKER

CONTROL LINE

O/HT OVERHEAD TELEPHONE

UNDERGROUND BSL BACK SET LINE WATER METER RCP REINFORCED CONC PIPE HYDRANT CMP CORRUGATED METAL PIPE PVC PLASTIC PIPE BACK FLOW
PREVENTOR
FIRE DEPARTMENT
CONNECTION
FIRE PROTECTION
VALVE — FO — FIBER OPTIC CABLE O/HC OVERHEAD CABLE MTL METAL AGL ABOVE GROUND LEVEL © CABLE BOX F.P. FOOTPRINT © CABLE PEDESTAL DECIDUOUS TREE HOSE BIBB UNDERGROUND
CABLE MARKER
TELECOMMUNICATIONS /s LANDSCAPING CONTROL VALVE IRRIGATION CONTROL CONIFER TREE MANHOLE
TELECOMMUNICATIONS
PEDESTAL
TRAFFIC POLE SQUARE METAL LID RECLAMED WATER FUEL TANK LID WATER VAULT FLAG POLE GAS VALVE TRAFFIC SIGNAL **ONLY UNKNOWN MANHOLE** GAS METER FROZEN MANHOLE TRAFFIC MANHOLE UNDERGROUND GAS MARKER GAS PEDESTAL UV UNKNOWN VAULT TRAFFIC SIGNAL BOX UVM UNKNOWN VAULT METAL TRAFFIC VAULT G GAS MANHOLE
G GAS LINE **UNKNOWN VALVE** STOP SIGN MB MAIL BOX PPT PROPANE TANK SIGN BOLLARD

GUARD RAIL

Know what's **below. Call** before you dig.

GRAPHIC SCALE

(IN FEET) 1 inch = 40 ft.

___ FENCE

PROPOSED LEGEND:

BORE HOLE

M.W MONITORING WELL

PROPERTY LINE PROPOSED LEASE LINE PROPOSED CURB

PROPOSED SITE LIGHT, SEE PHOTOMETRIC PLAN

PROPOSED DRAINAGE STRUCTURES (SEE GRADING/DRAINAGE PLANS) PROPOSED PARKING SPACES

GreenbergFarrow

t: 404 601 4000 f: 404 601 3970

This drawing is the property of the above

referenced Professional and is not to be used

for any purpose other than the specific

project and site named herein, and cannot

express written permission from the Professional

be reproduced in any manner without the

1430 W. Peachtree St. NW

Atlanta, GA 30309

Suite 200




Project No. 20191177.0 Scale 1:20


Drawn NICOLE NOVACK Checked STEPHEN POWERS Date 12-01-20

OVERALL

SITE PLAN


C-0.1

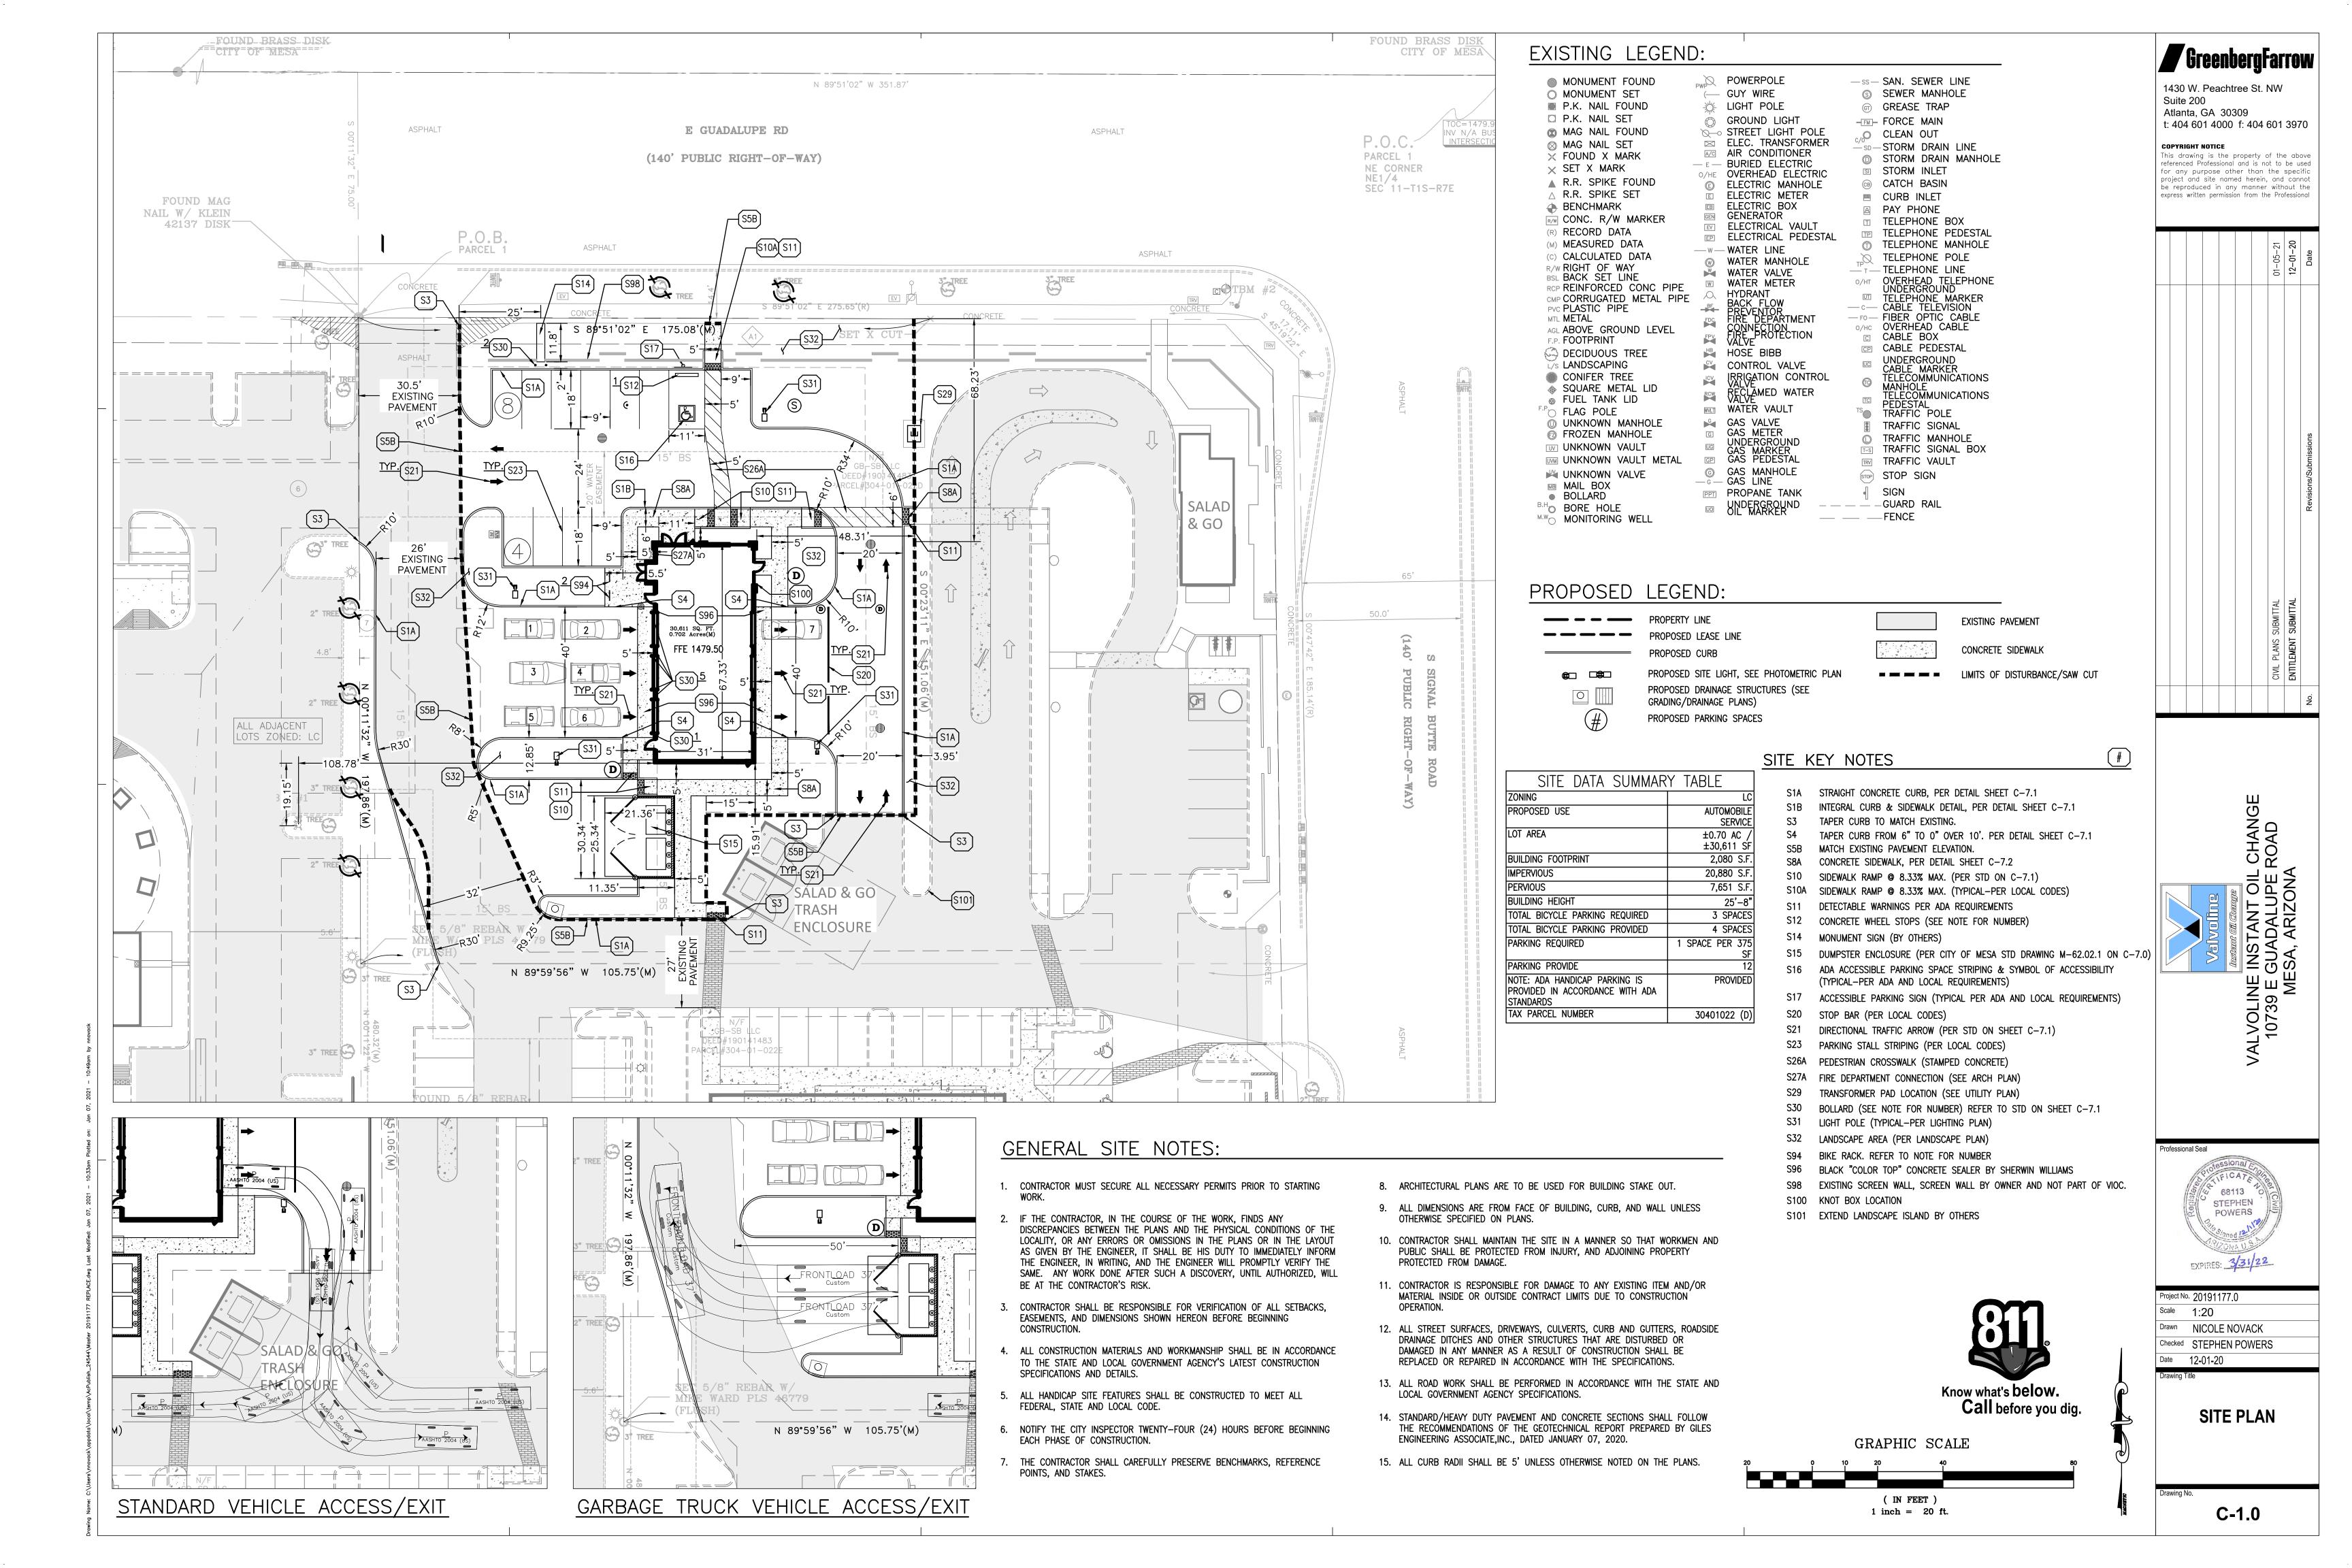

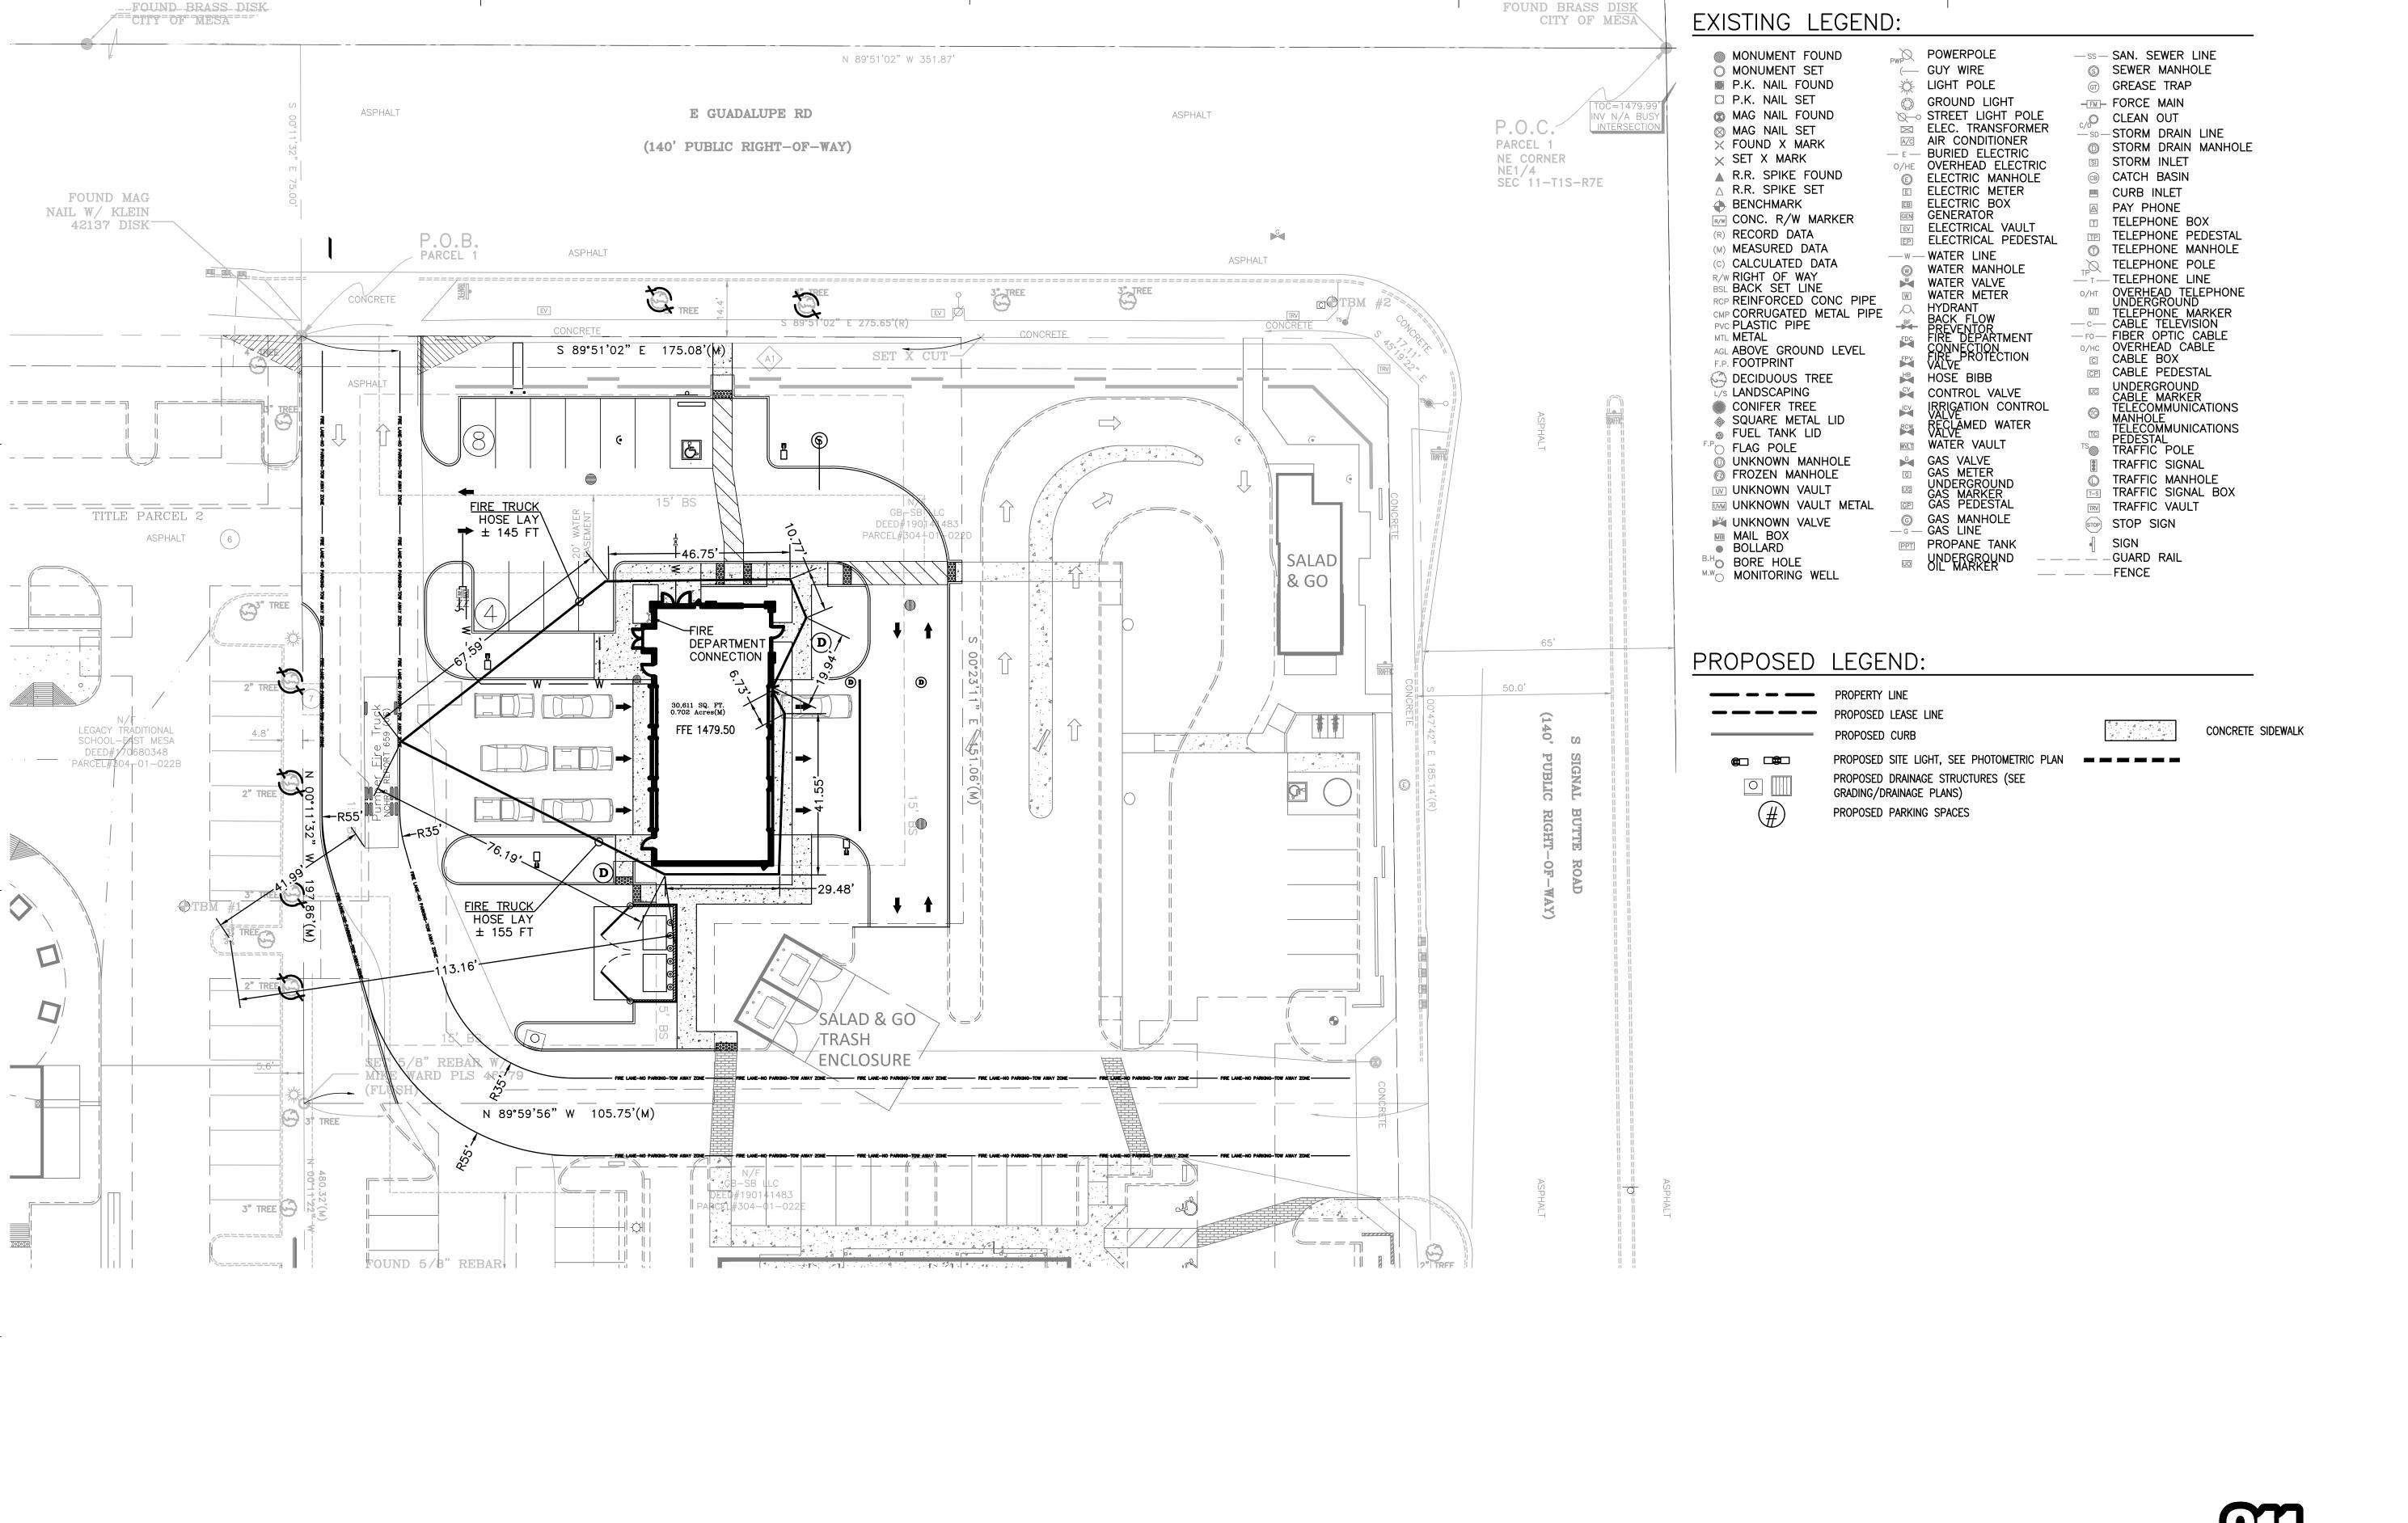



GRAPHIC SCALE

 


GreenbergFarrow

1430 W. Peachtree St. NW Suite 200 Atlanta, GA 30309

t: 404 601 4000 f: 404 601 3970

COPYRIGHT NOTICE This drawing is the property of the above referenced Professional and is not to be used for any purpose other than the specific project and site named herein, and cannot be reproduced in any manner without the express written permission from the Professional

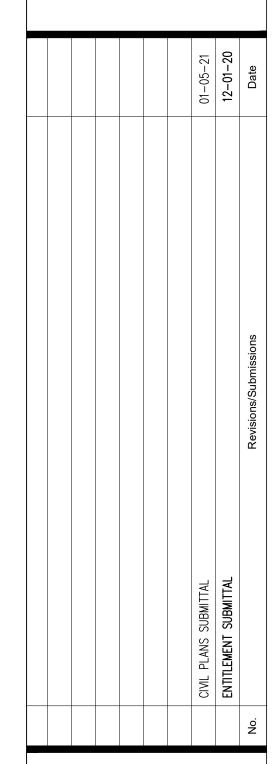



Project No. 20191177.0 Scale 1:20

Drawn NICOLE NOVACK Checked STEPHEN POWERS Date 12-01-20

FIRE PLAN

C-1.2

