 


A QSSI COMPANY

SoftLED LumaLens Opal Array Lens







Specifications and Features:

Housing:Extruded Aluminum Housing with Flush Mounting Base & Vandal-Resistant Screws, Flat Top, Internal Ballast Tray for Easy Maintenance. Bollards Can Be Cut to Custom Lengths

Listing & Ratings: CSA: Listed for Wet Locations, ANSI/UL 1598, 8750; IP65 Sealed LED Compartment.

Textured Architectural Bronze or Black Powdercoat Finish Over a Chromate Conversion Coating. Custom Colors Available Upon Request.

Clear Prismatic Borosilicate Glass Refractor, Specially Designed Cone Reflector or

Clear UV-Stabilized Polycarbonate Vandal-Resistant Lens or SoftLED LumaLens UV-Stabilized Polycarbonate Opal Vandal-Resistant Lens

Mounting Options: Mounting Kit with 8" Zinc-Plated Anchor Bolts, Included.


EasyLED LED:

Wattage:Array: 10w, System: 11.3w; (70w HID Equivalent) Array: 14.5w, System: 17w; (70w HID Equivalent) Array: 22w, System: 23.8w; (70w HID Equivalent)

Electronic Driver, 120-277V, 50/60Hz or 347V, 50/60Hz (15w Only); Less Than 20% THD and PF>0.90. Standard Internal Surge Protection 2kV. 0-10V Dimming Standard for a Dimming Range of 100% to 10%; Dimming Source Current is 150 Microamps.

Fixtures Ordered with Factory-Installed Motion Sensor Controls are Internally Wired for Switching and/or 1-10V Dimming Within the Housing. Remote Direct Wired Interface of 1-10V Dimming is Not Implied and May Not Be Available, Please Consult Factory. Fixtures are Tested with LEPG Controls and May Not Function Property With Controls Supplied By Others. Fixtures are NOT Designed for Use with Line Voltage Dimmers.

Warranty: 5-Year Warranty for -40°C to +40°C Environment. See Page 4 for Projected Lumen Maintenance Table.

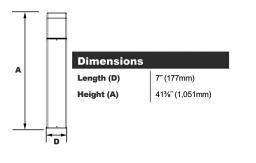

MATERIALS FINISH SCHEDULE

MATERIAL

STUCCO SYSTEM | Body Color / SIDING

STUCCO SYSTEM Body Color/Site Walls/Siding

ROOF TILE

REGULAR 8 X 8 X 16 CMU BLOCK PAINTED PT-4

SPLIT FACE 8 X 8 X 16 CMU BLOCK PAINTED PT-4

REGULAR 8 X 8 X 16 MASONRY CAP

(CMU-4) 8 X 8 X 16 RIBBED BLOCK PAINTED PT-4

Railing / Front Doors

Railing / Fasica / Gar. Doors

STUCCO SYSTEM Trim

STUCCO SYSTEM

SIDING WALLS

WROUGHT IRON / PAINT

STONE VENEER | STONE

STUCCO SYSTEM Body Color

1-KOTE

1-KOTE

1-KOTE

WOOD

CONCRETE

ROOF TILE

PT-2

PT-3

PT-4

PT-7

R-1

ST-1

 $\langle \mathsf{CMU-1} \rangle |$

 $\langle CMU-3 \rangle$







PENICO Lighting Products 150 Pemco Way-Wilmington, DE 19804 Phone 302.892.9000 Fax 302.892.9005 www.pemcolighting.com info@pemcolighting.com Cav19-pg1(2020) Specifications subject to change without notice. Rev. 121620

8 LIGHT BOLLARD DETAIL SCALE: N.T.S.

MANUFACTURER COLOR / MATERIAL

Dunn Edwards

Dunn Edwards

Dunn Edwards

Dunn Edwards

Dunn Edwards

Dunn Edwards

PRODUCT CODE

Barnwood Gray

DET620

Birchwood

DEC752

DEC755

DET631

Nomad

Sherwin -Williams | Quaker Bronze

DET697

Pigeon Grey

Roof Tile Fnish

CapistranoBrown, Black Flashed

Element Ledgstone

-Mouont Vernon


DE6214

Cocoa Powder

Cocoa

CAVALIER 19 SPECIAL NOTE:

CONTRACTOR SHALL INSTALL 2-1/2" EMPTY CONDUIT TO SRP POINT OF CONNECTION PER SRP SPECIFICATIONS & REQUIREMENTS. THIS LOCATION TO BE DETERMINED BY SRP AND SHALL BE COORDINATED WITH SRP.

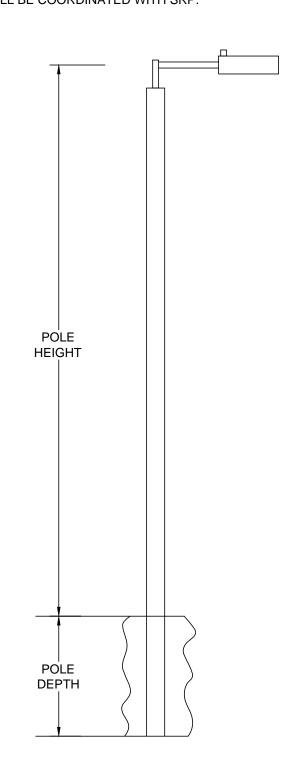

MOUNTING	POLE		POLE	PO
HEIGHT:	DEPTH:	LUMENS:	SHAPE:	CO
15'-0"	3'-6"	9500	SQUARE	BR

6 LIGHT POLE DETAIL SCALE: NTS

LuxMaster Series 53 Area Lighting

70-150W HPS, 100-175W MH

Durable die-cast aluminum housing for long-life performance


Applications:

Parking lots

Optical assembly designed for maximum per formance Removable ballast tray electrical system for installation and maintenance ease Breathing Seal" developed by American Electric prevents contaminants fron entering optical assembly for maximum efficiency Optics available in flat tempered glass, sag glass, drop acrylic and drop Available in a variety of IES light distributions patterns and cutoff classifications Standard product is designed to mount to pipe mast arm. Direct pole mount arms are available All electrical components warranted by American Electric Lighting's 6-year

UL Listed Residential communities Mogul base, E39, socket standard Commercial environments Suitable for -30°CMH / -40°C HPS Office communities Complies with ANSI: C136.2, C136.10, C136.14, C136.15

Features:

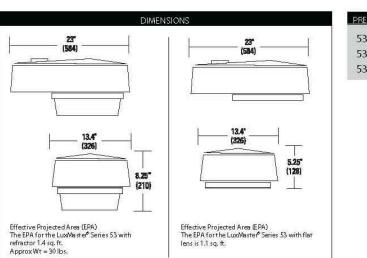


LIGHT FIXTURE


SPECIFICATION FOR SA LIGHT FIXTURE


53 10S CA MT1 R2 DA 53 15S CA MT1 R2 FG 53 10S RH 120 R3 FG

AEL American

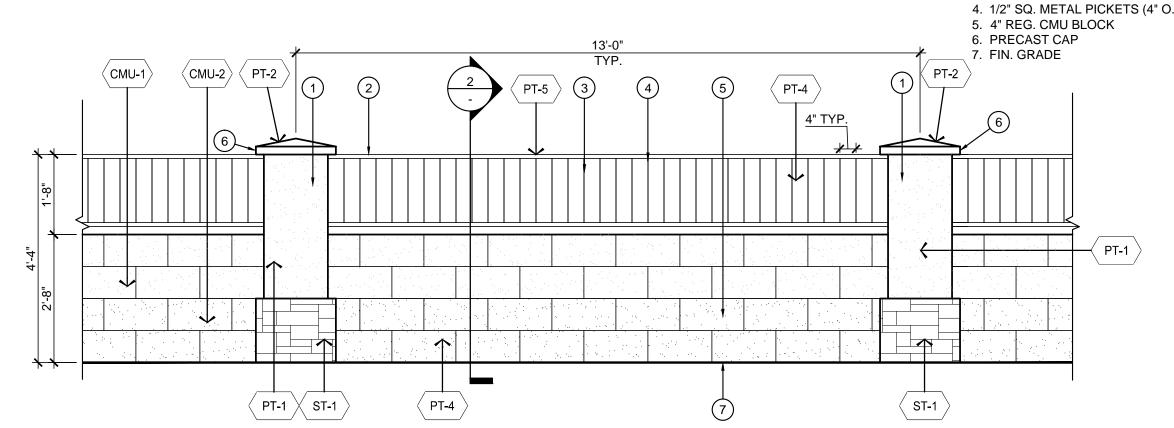

MASONRY/WROUGHT IRON COMBO THEME WALL - ELEVATION

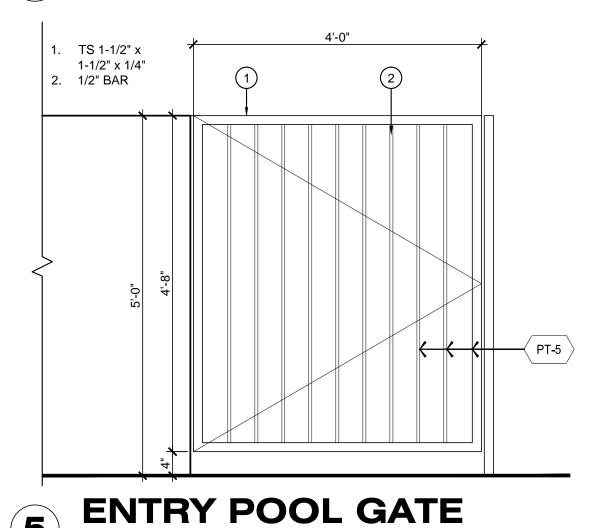

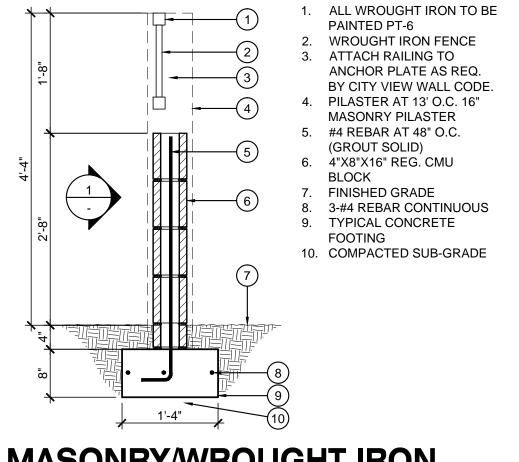

1. PILASTERS

3. 1" SQ. STEEL RAIL

2. WROUGHT IRON FENCE

project

610 E Bell Rd #2-607. Phoenix AZ 85022 phone: 602/910-7728 fax: 480/359-4407

e-mail: info@e-projectinternational.com

Date Submittal

10-30-2020 PRE-APPLICATION

02-15-2021 Preliminary Site Plan

04-15-2021 2nd Review DRB Submittal

EDMIR

DZUDZA

EXPIRATION DATE: 09/30/2023

SIGNED AND SEALED

Copyright reserved: **e-project** 2020-2021

ELECTRONICALLY 04-15-2021

This document / drawing is protected by federal copyright law. No

against persons found copying this document without permission ©

copies, reproductions or electronic transfer of this document /


drawing may be made without written authorization. Civil proceedings claiming damages or other remidies may be brought

Submittal

MASONRY/WROUGHT IRON 2 COMBO THEME WALL DETAIL

SCALE: 3/4"=1'-0"

3 4'-0" 1. TS 1-1/2" x 1-1/2" x 1/4" MASONRY CAP \langle PT-4 \rangle CMU-1

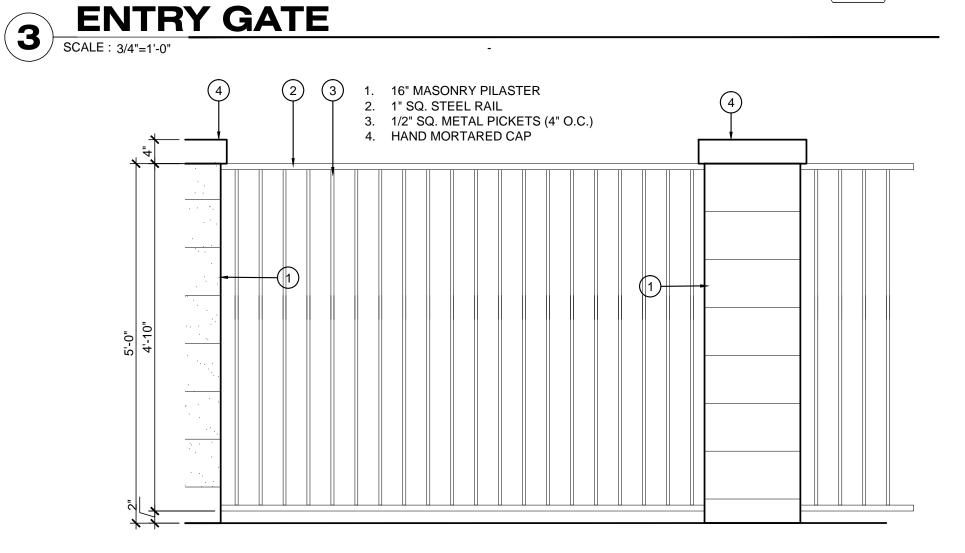

TYPICAL POOL FENCE ELEVATION

SCALE: 3/4"=1'-0"

Date:	04-15-2021
Project No.	7620
Drawn By:	AP
Checked By:	AP
Approved By:	ED

AS NOTED